



FIRE TRUCK DATA

LENGTH	46'-10"
BUMPER TO BUMPER	32'-0"
WHEELBASE	256"

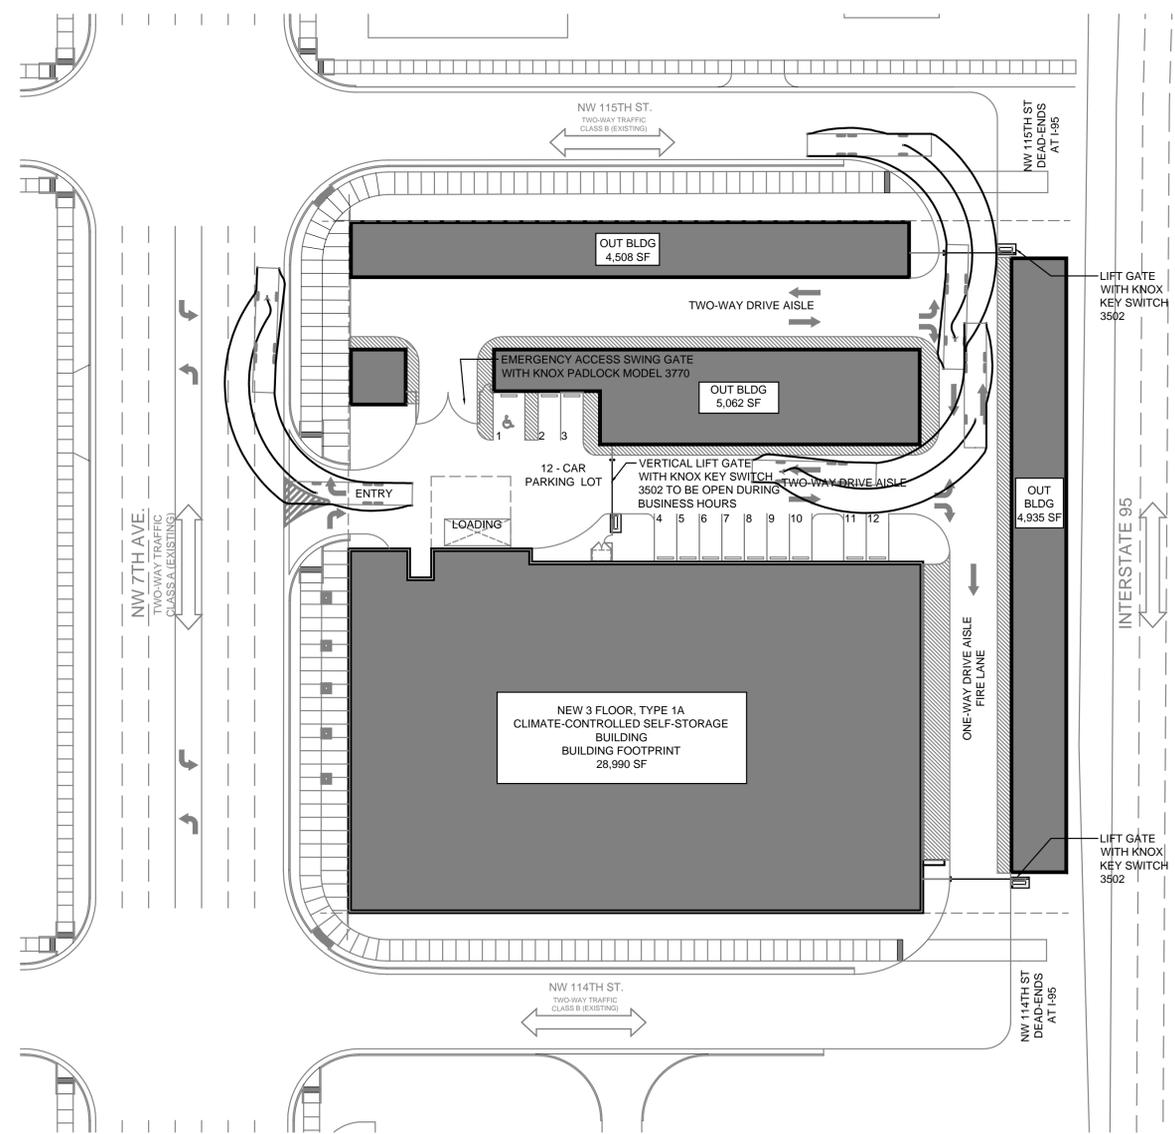

2 FIRE TRUCK TURNING RADIUS
 SCALE: 1/32" = 1'-0"

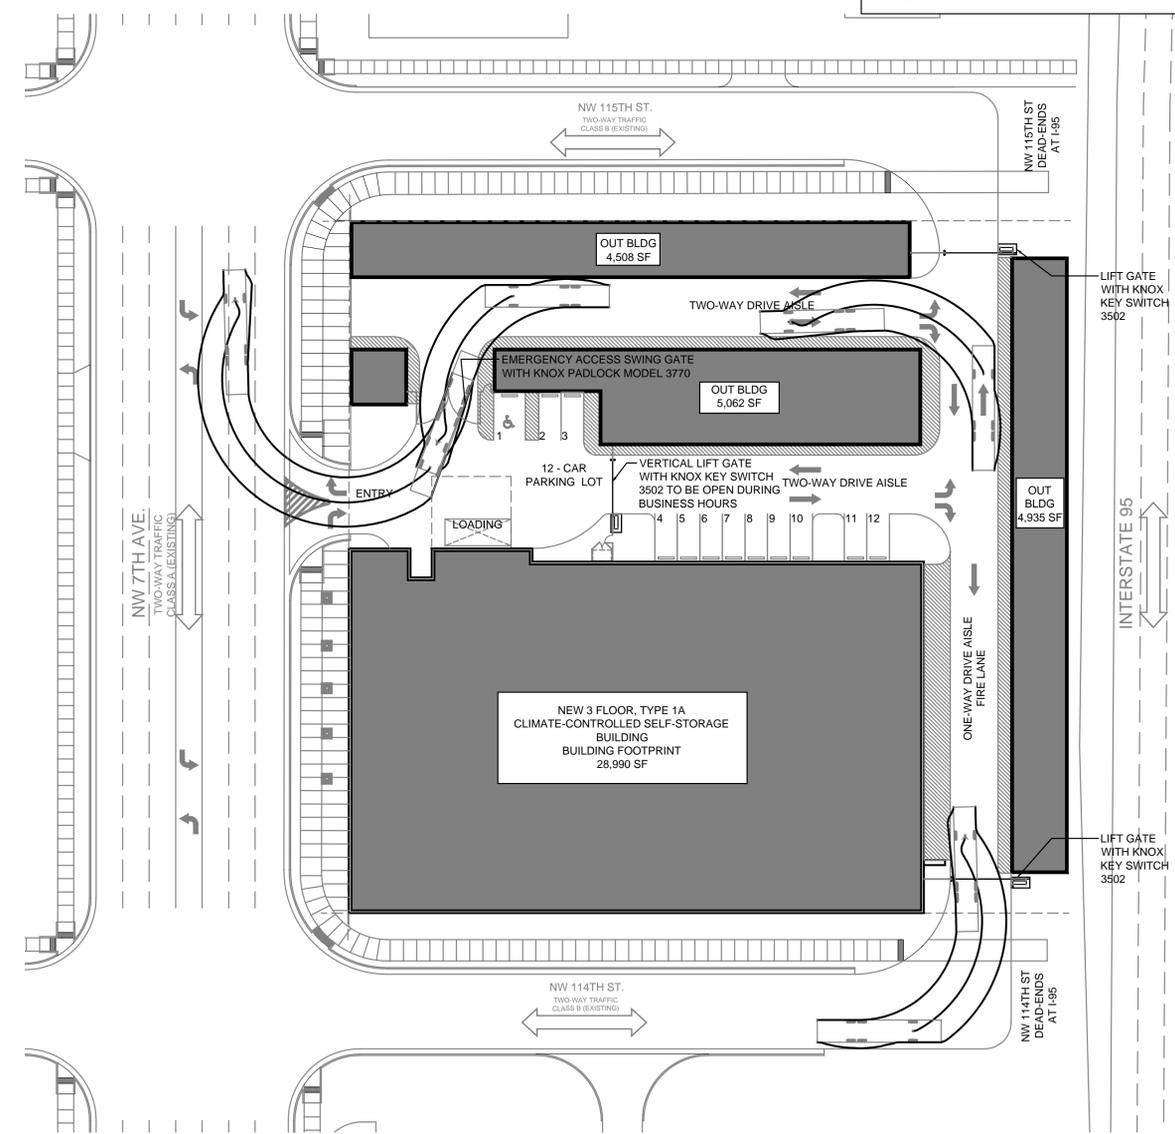

1 FIRE TRUCK TURNING RADIUS
 SCALE: 1/32" = 1'-0"

NOTES:
 • ALL DRIVEWAY RAMPS WILL BE ADA COMPLIANT

NO.	DATE	ISSUE DESCRIPTION
4	09/21/2015	ADMIN SITE PLAN REVIEW
3	09/04/2015	APPLICATION CORRECTIONS
2	08/12/2015	PRE-APP. CORRECTIONS
1	07/15/2015	PRE-APPLICATION REVIEW

12/14/2015 ZONING REVIEW
 12/08/2015 FIRE REVISIONS

PRINCIPAL: MS P.M.: CM
 QC BY: DRAWN BY: BMCC

**SULLIVAN
 GOULLETTE
 & WILSON**
 ARCHITECTS
 444 N. MICHIGAN AVENUE
 SUITE 1850
 CHICAGO, IL 60611
 Ph. 312. 988. 7412
 Fx. 312. 988. 7409
 www.sgwarch.com
 PROFESSIONAL DESIGN FIRM
 License Number: 184-001505
 Expiration Date: April 30, 2017

11459 NW 7th AVENUE

MIAMI, FLORIDA 33168

FIRE TRUCK RADIUS

NORTH
 A0-1A