


RECEIVED
MIAMI-DADE COUNTY
PROCESS # 266-192
DATE: AUG 13 2007
BY: SDE

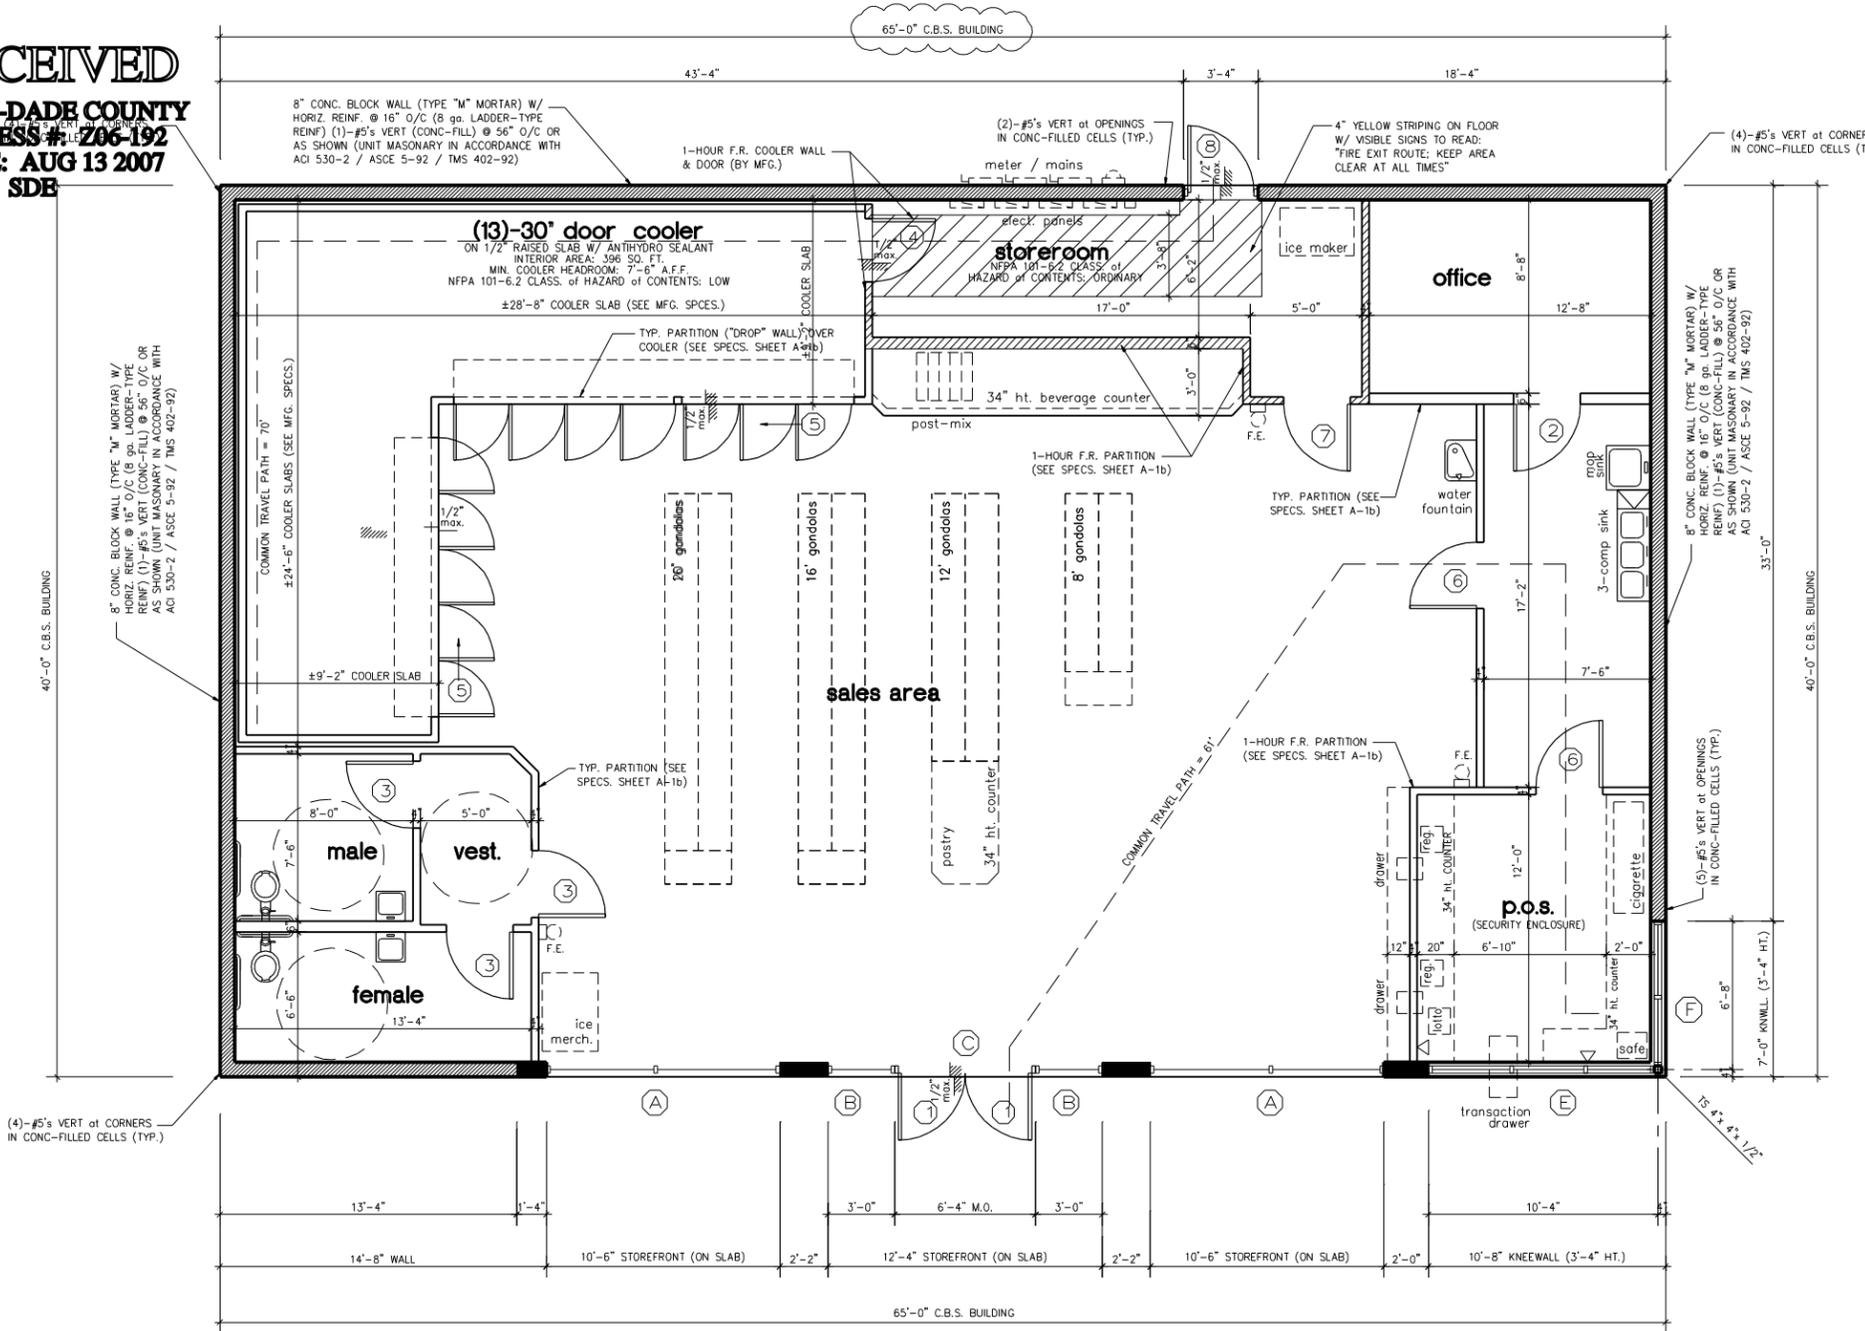

FLOOR PLAN

scale: 1/4"=1'-0"

13990 SW 97th AVENUE
 miami, florida 33176
 telephone: 305 992-6928
 beeper: 305 715-8007
 fax: 305 235-7291

E.G.N. INC.
ENGINEERING
 A.M. PASCOAL, P.E. CIVIL: 46747

Date: 06/15/06
 By: JES
 Chk:
 Scale: 1/4"=1'-0"
 Job No: 573
 Rev: Date:

MIAMI-DADE COUNTY, FLORIDA

FLOOR PLAN
LIBERTY STATION
 1933 W. DIXIE HIGHWAY.

A-1a

NOTES:
 - CONTRACTOR SHALL BE RESPONSIBLE FOR THE LOCATION OR RELOCATION OF GAS LINES IN THE PATH OF CONSTRUCTION
 - TAKE-OUT FOOD SERVICE ONLY. NO CONSUMPTION OF FOOD OR BEVERAGES ON PREMISES. NO TABLES OR COUNTERS PERMITTED.