

MANUFACTURE & INSTALL FOUR DOUBLE FACED, NON ILLUMINATED CORNER BANNERS.

13oz BANNER MATERIAL WITH PRINTED GRAPHICS APPLIED FIRST SURFACE. BANNERS TO BE ATTACHED AND CHEMICALLY BONDED BACK TO BACK WITH SEWN POCKETS AT TOP AND BOTTOM TO ACCOMMODATE 3" DIA. TUBING.

BANNERS TO ATTACH AT CORNER WALL USING CUSTOM FABRICATED .125 ALUMINUM BRACKETS WELDED TO 6" DIA ALUMINUM PIPE WITH 3" DIA. ALUMINUM HANGER ROD HAVING FABRICATED .040 ALUMINUM STOPS. TO MOUNT AT WALL USING 3/8" HARDWARE AS REQ'D.

RECEIVED
 215-135
 DEC 22 2015
 MIAMI-DADE COUNTY
 DEPARTMENT OF REGULATORY AND
 ECONOMIC RESOURCES
 DEVELOPMENT SERVICES

For DAH



INTEGRATED



INTEGRATED SIGN ENGINEERING & DESIGN
 7007 Webber Road Sarasota, FL 34240
 Phone: 941.379.5911 Cell: 941.302.1745
 Fax: 941.379.5919 Email: JLee@ISED@aol.com

DESIGN #14C283-R0-1/1 DATE: 9/11/14

SCALE: 3/8" = 1' 0"

DRAWN BY: MB

JOB NAME: ROOMS TO GO

ADDRESS:

CITY: MIAMI STATE: FL ZIP:

CUSTOMER APPROVAL

APPROVED APPROVED AS NOTED

DATE: / /


BY: _____

THIS DESIGN (EXCEPT REGISTERED OR EXISTING TRADEMARKS) IS THE PROPERTY OF INTEGRATED SIGN ENGINEERING & DESIGN AND SHALL NOT BE USED, REPRODUCED OR COPIED IN WHOLE OR IN PART WITHOUT WRITTEN PERMISSION.

This sign is intended to be installed in accordance with the requirements of article 600 of the national electrical code and/or other applicable local codes. This includes proper grounding and bonding of the sign. This sign has been designed in accordance with the florida building code 2010.



EAST ELEVATION - NORTH BUILDING
1/16" = 1'-0"

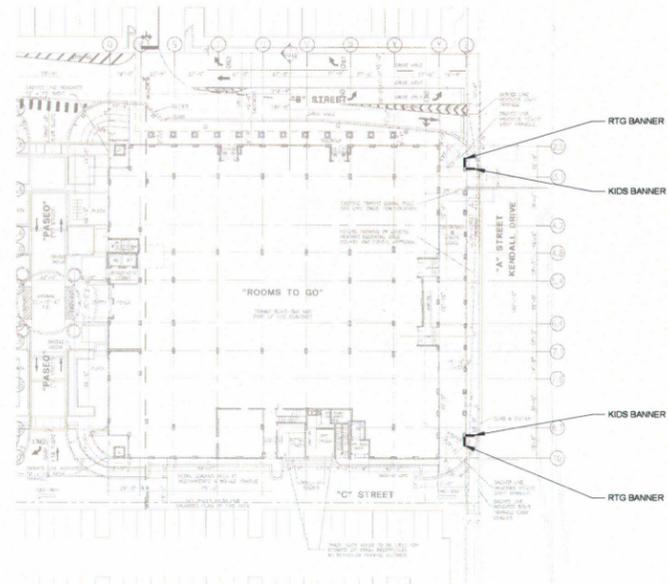

FLOOR PLAN
1/62" = 1'-0"



RECEIVED
215-135
DEC 22 2015
MIAMI-DADE COUNTY
DEPARTMENT OF REGULATORY AND
ECONOMIC RESOURCES
DEVELOPMENT SERVICES
FOR DAH



NORTH ELEVATION - NORTH BUILDING
1/16" = 1'-0"



WEST ELEVATION - NORTH BUILDING
1/16" = 1'-0"

MANUFACTURE & INSTALL FOUR DOUBLE FACED, NON ILLUMINATED CORNER BANNERS.

1.3oz BANNER MATERIAL WITH PRINTED GRAPHICS APPLIED FIRST SURFACE. BANNERS TO BE ATTACHED AND ORIENTALLY BONDED BACK TO BACK WITH SEWN POCKETS AT TOP AND BOTTOM TO ACCOMMODATE 3" DIA. TUBING.

BANNERS TO ATTACH AT CORNER WALL USING CUSTOM FABRICATED .125 ALUMINUM BRACKETS WELDED TO 6" DIA ALUMINUM PIPE WITH 3" DIA. ALUMINUM HANGER ROD HAVING FABRICATED .040 ALUMINUM STOPS. TO MOUNT AT WALL USING 3/8" HARDWARE AS REQ'D.

PLAN VIEW
SCALE: 1/2" = 1'-0"

	<p>INTEGRATED SIGN ENGINEERING & DESIGN 2000 NW 10th Street, Suite 101 Miami, FL 33136 Phone: 305.374.9311 Fax: 305.374.9315 www.integratedsign.com</p>	<p>DESIGN #14C283-R0-1/1 DATE: 9/11/14 SCALE: 3/8" = 1' 0" DRAWN BY: MB</p>	<p>JOB NAME: ROOMS TO GO ADDRESS: CITY: MIAMI STATE: FL ZIP:</p>	<p>CUSTOMER APPROVAL <input type="checkbox"/> APPROVED <input type="checkbox"/> APPROVED AS NOTED DATE: / / BY:</p>	<p>THIS DESIGN (EXCEPT REGISTERED OR EXISTING TRADEMARKS) IS THE PROPERTY OF INTEGRATED SIGN ENGINEERING & DESIGN AND SHALL NOT BE USED, REPRODUCED OR COPIED IN WHOLE OR IN PART WITHOUT WRITTEN PERMISSION.</p>
--	--	---	--	--	---

This sign is intended to be installed in accordance with the requirements of article 600 of the national electrical code and/or other applicable local codes. This includes proper grounding and bonding of the sign. This sign has been designed in accordance with the Florida building code 2010.



ROOMS TO GO
FAIRFIELD DADELAND
MIAMI, FLORIDA
12/8/2015